



937C RUSSELL AVENUE,
GAITHERSBURG, MARYLAND 20879
TEL 240-632-2281
FAX 240-632-2282

THIS DRAWING IS THE PROPERTY OF THE ARCHITECTS AND ANY PRODUCTION OR USE FOR ANY BUT THE SPECIFICALLY NAMED WORK PURPOSES WITHOUT THE PROOF WRITTEN CONSENT OF THE ARCHITECTS, IS STRICTLY PROHIBITED.

PROJECT NAME:

Montgomery County
Public Schools



PORTABLE CLASSROOMS
AT COLLEGE GARDEN
ELEMENTARY SCHOOL

1700 YALE PLACE
ROCKVILLE, MD 20850

SEAL:

PROFESSIONAL CERTIFICATION:
Professional Certification. I hereby certify that these documents were prepared or approved by me, and that I am a duly licensed professional architect under the laws of State of Maryland. License No. 13306, Expiration Date: 10/25/2010

ISSUED FOR:

DATE	DESCRIPTION
01/06/10	SCHEMATIC
02/11/10	100% SUBMISSION
02/26/10	PERMIT SET
03/29/10	2ND SCHEMATIC
04/13/10	2ND 100% SUBMISSION
04/15/10	PERMIT SET
04/15/10	BID SET

PROJECT NO: 0110b

SCALE: AS SHOWN

DRAWN BY: AA

CHECKED BY: JK


DATE: 05-17-10

SHEET TITLE:

SITE PLAN

DRAWING NO:

SP

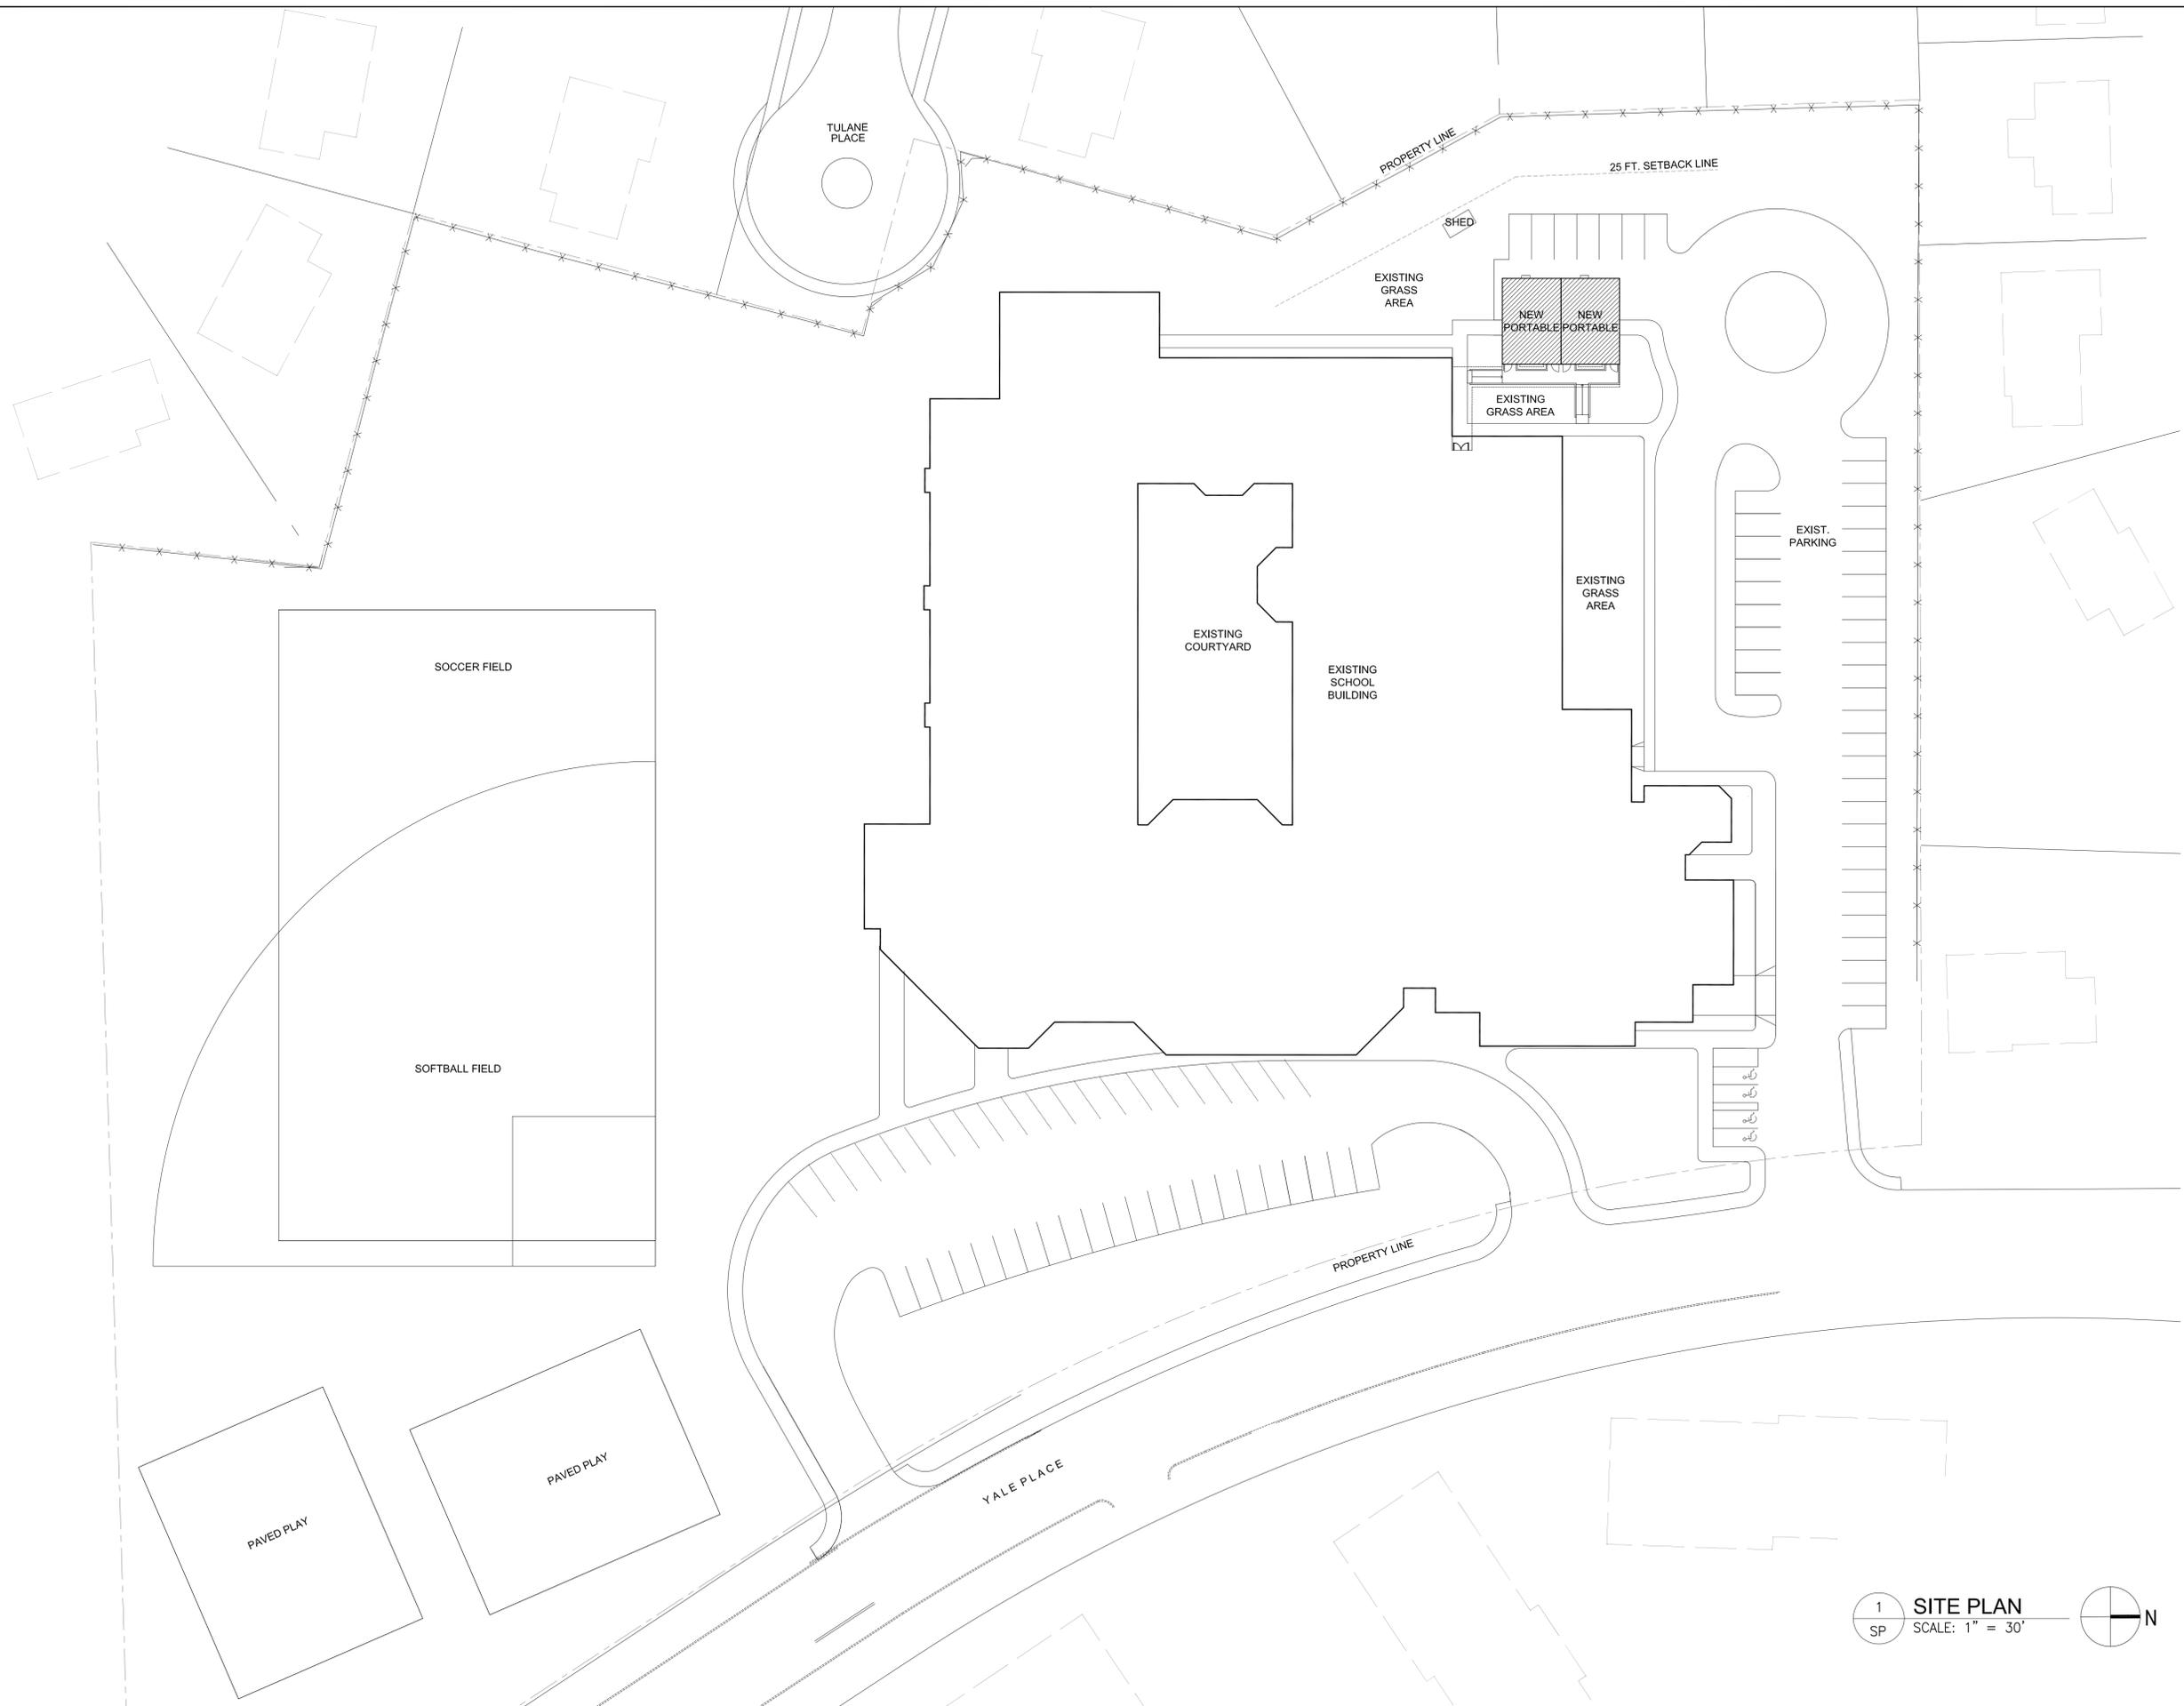

1 SITE PLAN
SP SCALE: 1" = 30'

